




FIXTURE SCHEDULE			
TAG	MODEL #	LOAD	QTY
EP	COOPER MCGRAW EDISON GLEON-AE-8-LED-5WQ-BZ-347-CSA (40K COLOR TEMP & 11.2M MOUNTING HEIGHT)	421W	EX
EP1	COOPER MCGRAW EDISON GLEON-AE-8-LED-SL3-HSS-BZ-347-CSA (40K COLOR TEMP & 11.2M MOUNTING HEIGHT)	421W	EX
EP2	COOPER MCGRAW EDISON GLEON-AE-8-LED-T3-BZ-347-CSA (40K COLOR TEMP & 11.2M MOUNTING HEIGHT)	421W	EX
EP3	COOPER MCGRAW EDISON GLEON-AE-8-LED-5WQ-BZ-347-CSA (40K COLOR TEMP & 11.2M MOUNTING HEIGHT)	421W	EX
P	GALN-SA6C-740-9-5WQ-BZ (11.2M MOUNTING HEIGHT)	321W	6
P1	GALN-SA6C-740-9-SL3-HSS-BZ (11.2M MOUNTING HEIGHT)	321W	2
P2	GALN-SA6C-740-9-SL4-HSS-BZ (11.2M MOUNTING HEIGHT)	321W	2
P3	GALN-SA6C-740-9-SL2-HZZ-BZ (11.2M MOUNTING HEIGHT)	321W	1

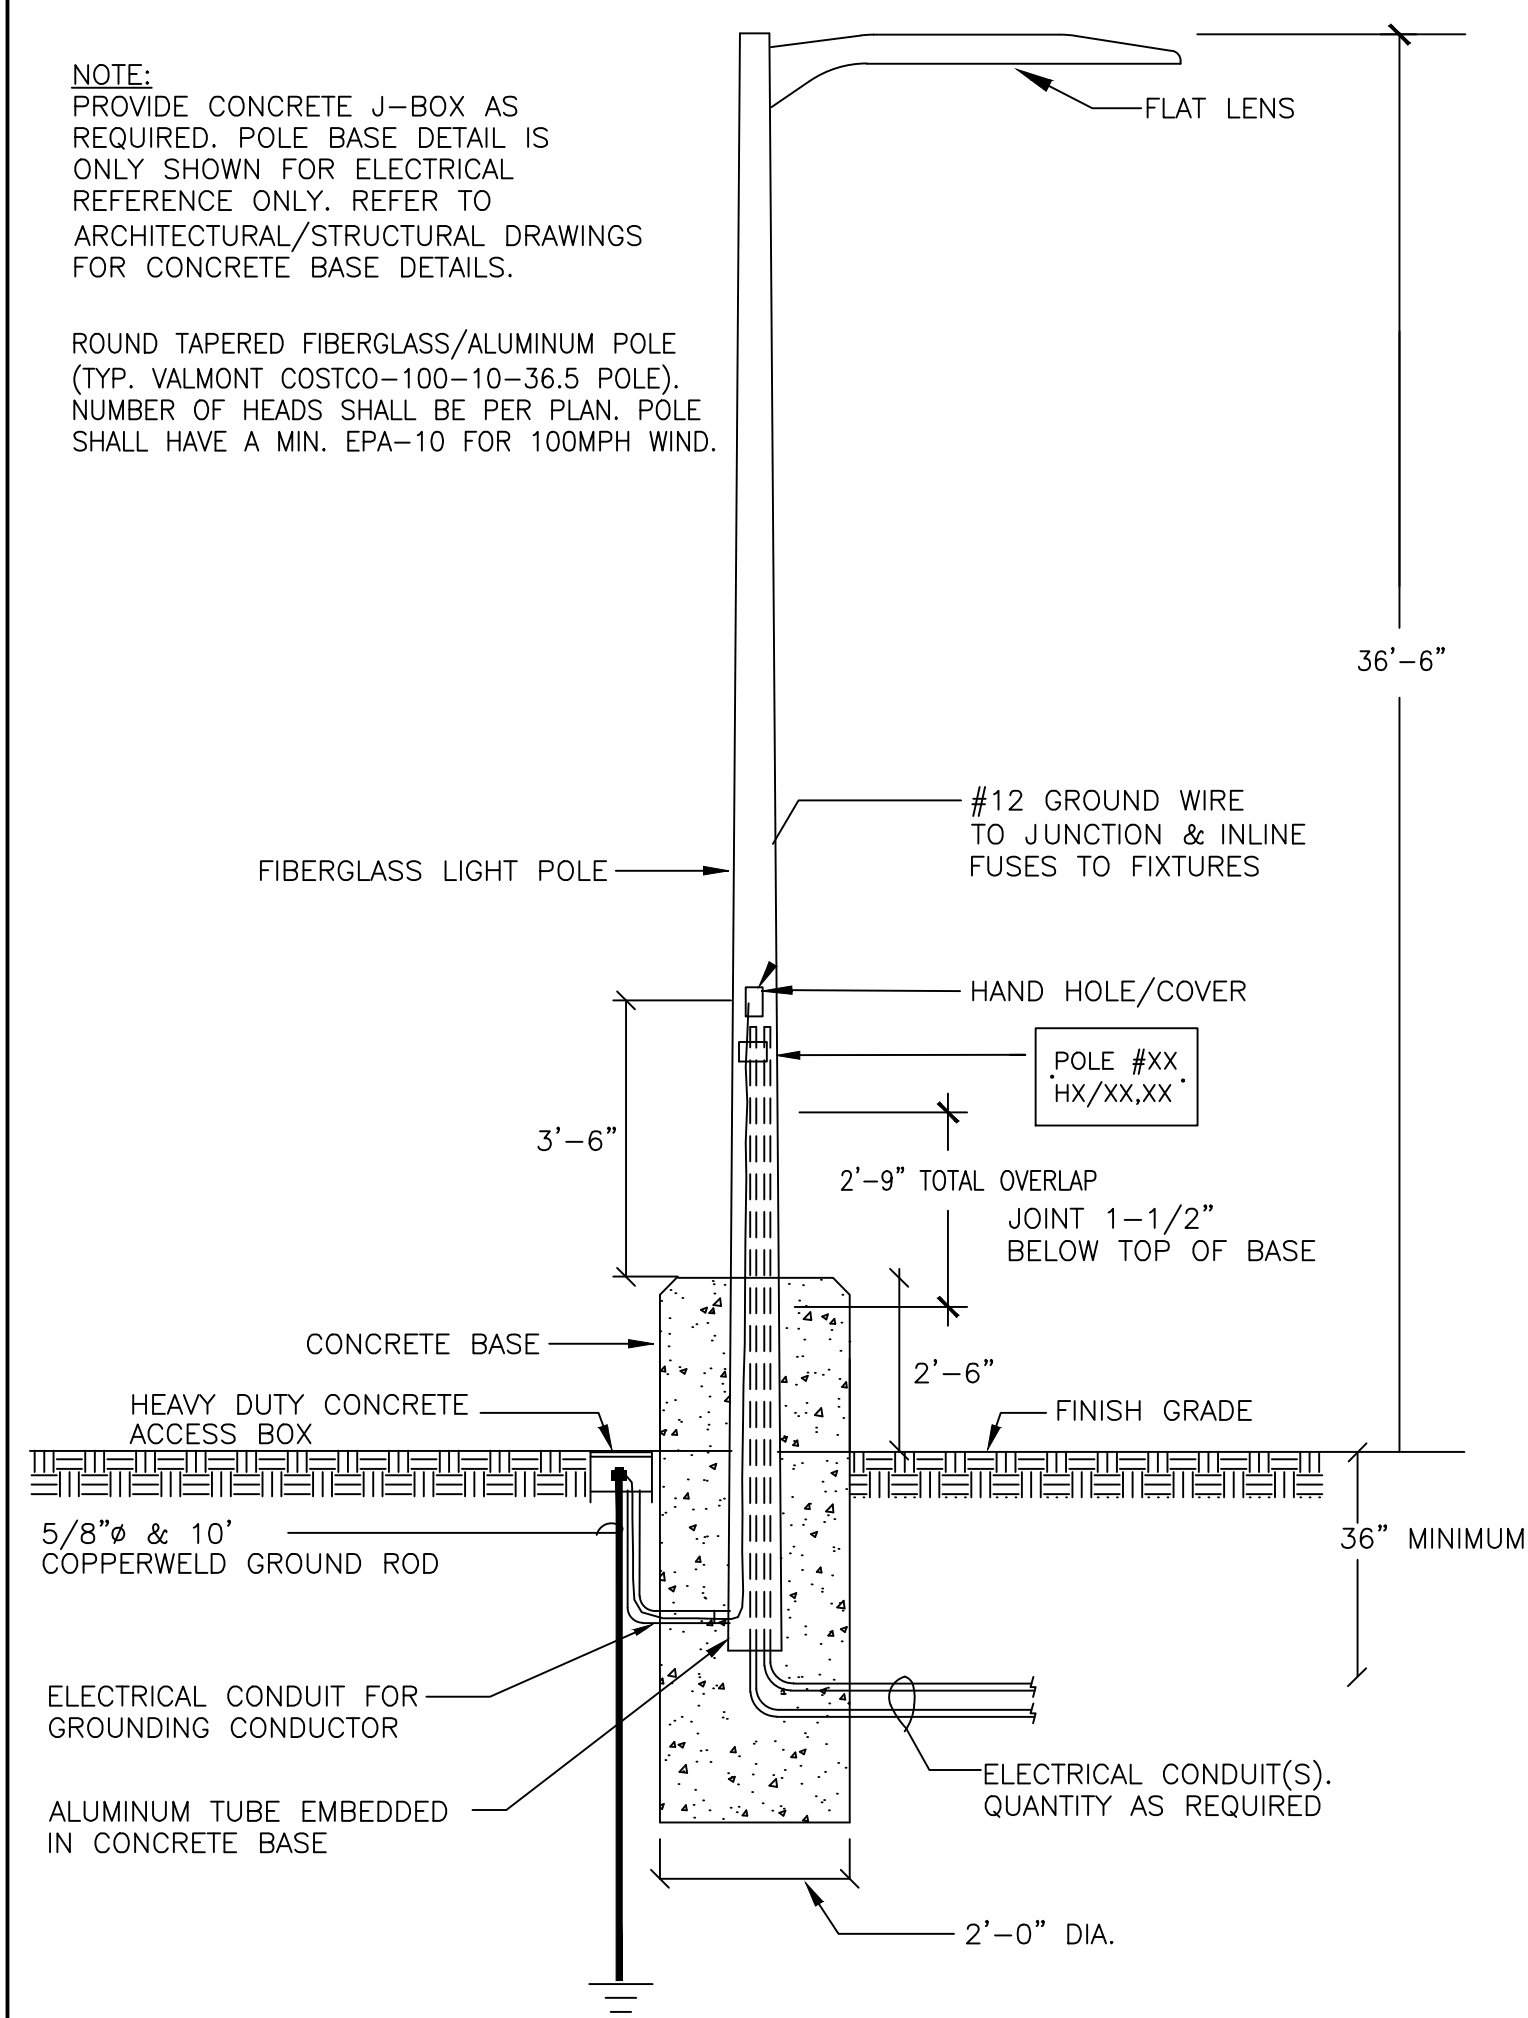

(2) TYPICAL YARD LIGHTING POLE DETAIL
- SCALE NTS



GENERAL NOTES:

1. VERIFY ALL DIMENSIONS PRIOR TO CONSTRUCTION.
2. DO NOT SCALE DRAWINGS.
3. REPORT ALL DISCOVERIES OF ERRORS, OMISSIONS OR DISCREPANCIES TO THE DESIGN ENGINEER AS APPLICABLE.
4. USE ONLY LATEST REVISED DRAWINGS OR THOSE THAT ARE MARKED "ISSUED FOR CONSTRUCTION".
5. DESIGN AND CONSTRUCTION OF THIS PROJECT SHALL COMPLY WITH THE PROVINCIAL AND LOCAL BUILDING CODES LATEST EDITION.
6. ALL WORKS AND MATERIALS USED SHALL COMPLY AS REQUIRED BY THE BUILDING CODE LATEST EDITION.
7. THIS DRAWING SHALL BE READ IN CONJUNCTION WITH ALL RELEVANT DRAWINGS & SPECIFICATIONS.
8. EVERYTHING IS TO BE CONSIDERED NEW UNLESS SPECIFIED EXISTING OTHERWISE.
9. THE CONTRACTOR SHALL APPLY FOR, OBTAIN AND PAY FOR ALL PERMITS, LICENSES, INSPECTIONS, EXAMINATIONS AND FEES REQUIRED.
10. REFER TO SITE ELECTRICAL DRAWINGS FOR CONDUIT/WIRE SIZES.
11. REFER TO ARCHITECTURAL/STRUCTURAL DRAWINGS AND MANUFACTURER SPECIFICATIONS FOR LIGHT POLE BASE REQUIREMENTS AND INSTALLATION DETAILS.
12. FOR ADDITIONAL REQUIREMENTS REFER TO CONTRACT DOCUMENTATION.

PHOTOMETRIC STUDY NOTES:

1. ALL EXTERIOR LUMINARIES, MUST BE CONNECTED TO A DAYLIGHT DETECTION SENSOR SET TO 1000 LUX.
2. FOR THIS STUDY, ONLY THE FIXTURES NOTED IN THE FIXTURE SCHEDULE WERE MODELED.
3. OFF-PROPERTY FIXTURES, BUILDING MOUNTED FIXTURES, AND ANY ILLUMINATED SIGNS WERE NOT MODELED.
4. LAYOUT IS BASED UPON INFORMATION RECEIVED TO DATE AND MOUNTING HEIGHTS NOTED IN THE FIXTURE SCHEDULE.

LEGEND:

- | | |
|---|--|
| +2.5 | ILLUMINANCE IN LUX AT THE GROUND LEVEL |
|  | LOCATION OF LUMINARY WITH LETTER
DENOTING TYPE OF FIXTURE |

[illegible]


No part of this document may be reproduced in any form
without permission in writing from J + B Engineering Inc.

J+B

J + B ENGINEERING INC.

TORONTO	CALGARY	416 228 2255
100 DUNDAS ST. W.	1000 10 th AVE. SW.	
SUITE 200	SUITE 200	
MARKHAM, ON L3R 5H8	CALGARY AB T2R 0E2	
416 228 2636	403 355 2255	

PARKING EXPANSION
1330 SOUTH SERVICE ROAD
STONE CREEK, ONTARIO
CANADA

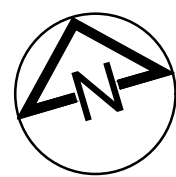The Costco Wholesale logo, featuring the word "Costco" in a large, bold, sans-serif font, and the word "WHOLESALE" in a smaller, bold, sans-serif font, with three horizontal lines above it.

J+B #: 250262
PM: FJ
CHECKED BY: GG
ISSUED: 09 JAN '26

SITE LIGHTING PLAN

SL-1