


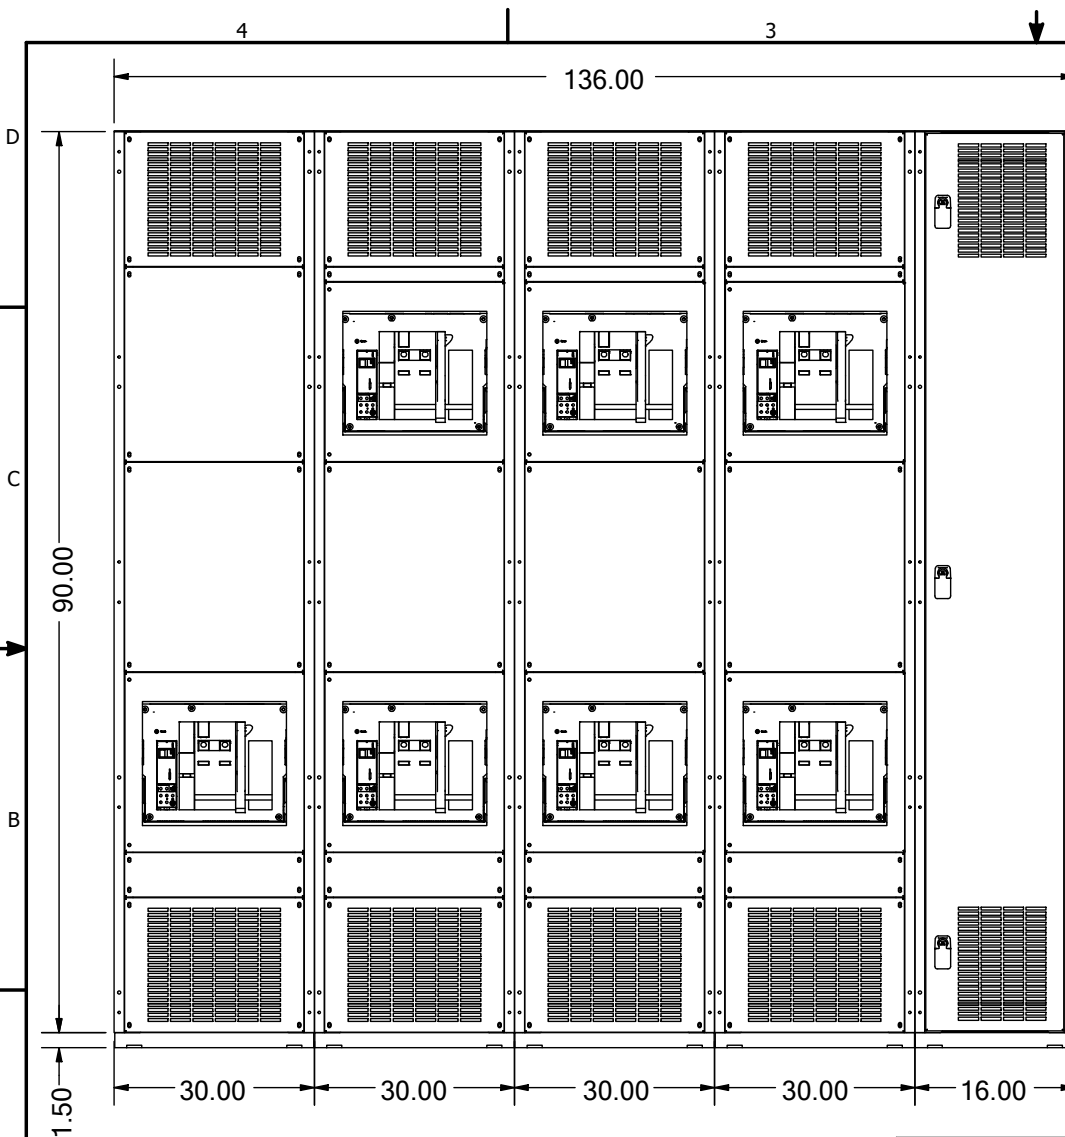

SWITCHBOARD GENERAL NOTES

Power System Data

277/480V 60Hz 3 Phase 4 Wire
Solidly Grounded
System Rating: 65 - 100kA RMS
Cable Through the Bottom/Top of Lineup

Bus System Data

1200 - 3000A Copper Plated w/Silver

Enclosure Data

NEMA 1 Free Standing
Exterior Paint Color: ANSI 49
Front Access Only
Handling: Rollers

Code Standards

U.L. Deadfront and suitable for use as Service Entrance when not more than six (6) disconnecting means are provided

Rating Nameplates

ST1 - Dead Front Section - Section Bus 1200 - 3000A
ST2 - Dead Front Section - Section Bus 1200 - 3000A
ST3 - Dead Front Section - Section Bus 1200 - 3000A
ST4 - Dead Front Section - Section Bus 1200 - 3000A
ST5 - Dead Front Section - Section Bus 1200 - 3000A

Wiring

 
All wiring to be Machine Tool / SIS Wire type

Instruction Bulletins

Refer As Built Drawings & Instructions

Product Accessories/Options

Energy Reduction Maintenance Switch (#)
SKRU Scheme MBB & SIB
Key Release Button
"UPS On Maintenance Bypass" Light




PowerStream Solutions


1151 B Underwood Rd.
Aledo, TX 76008

www.powerstreamolutions.com

This drawing is the property of Power Stream Solutions and may not be used or reproduced without our written permission and must be returned per our request.


REVISION				
-				
APPROVED BY	APPROVED DATE	CUSTOMER/REFERENCE NAME	DESIGNATION	DRAWING STATUS
PF	3/20/2026	-	-	QUOTATION
DRAFTED BY	DRAFTED DATE	PSS JOB No. OR DRAWING No.	DRAWING DESCRIPTION	SHEET
PF	3/20/2026	-	FRONT ELEVATION	1 OF 4

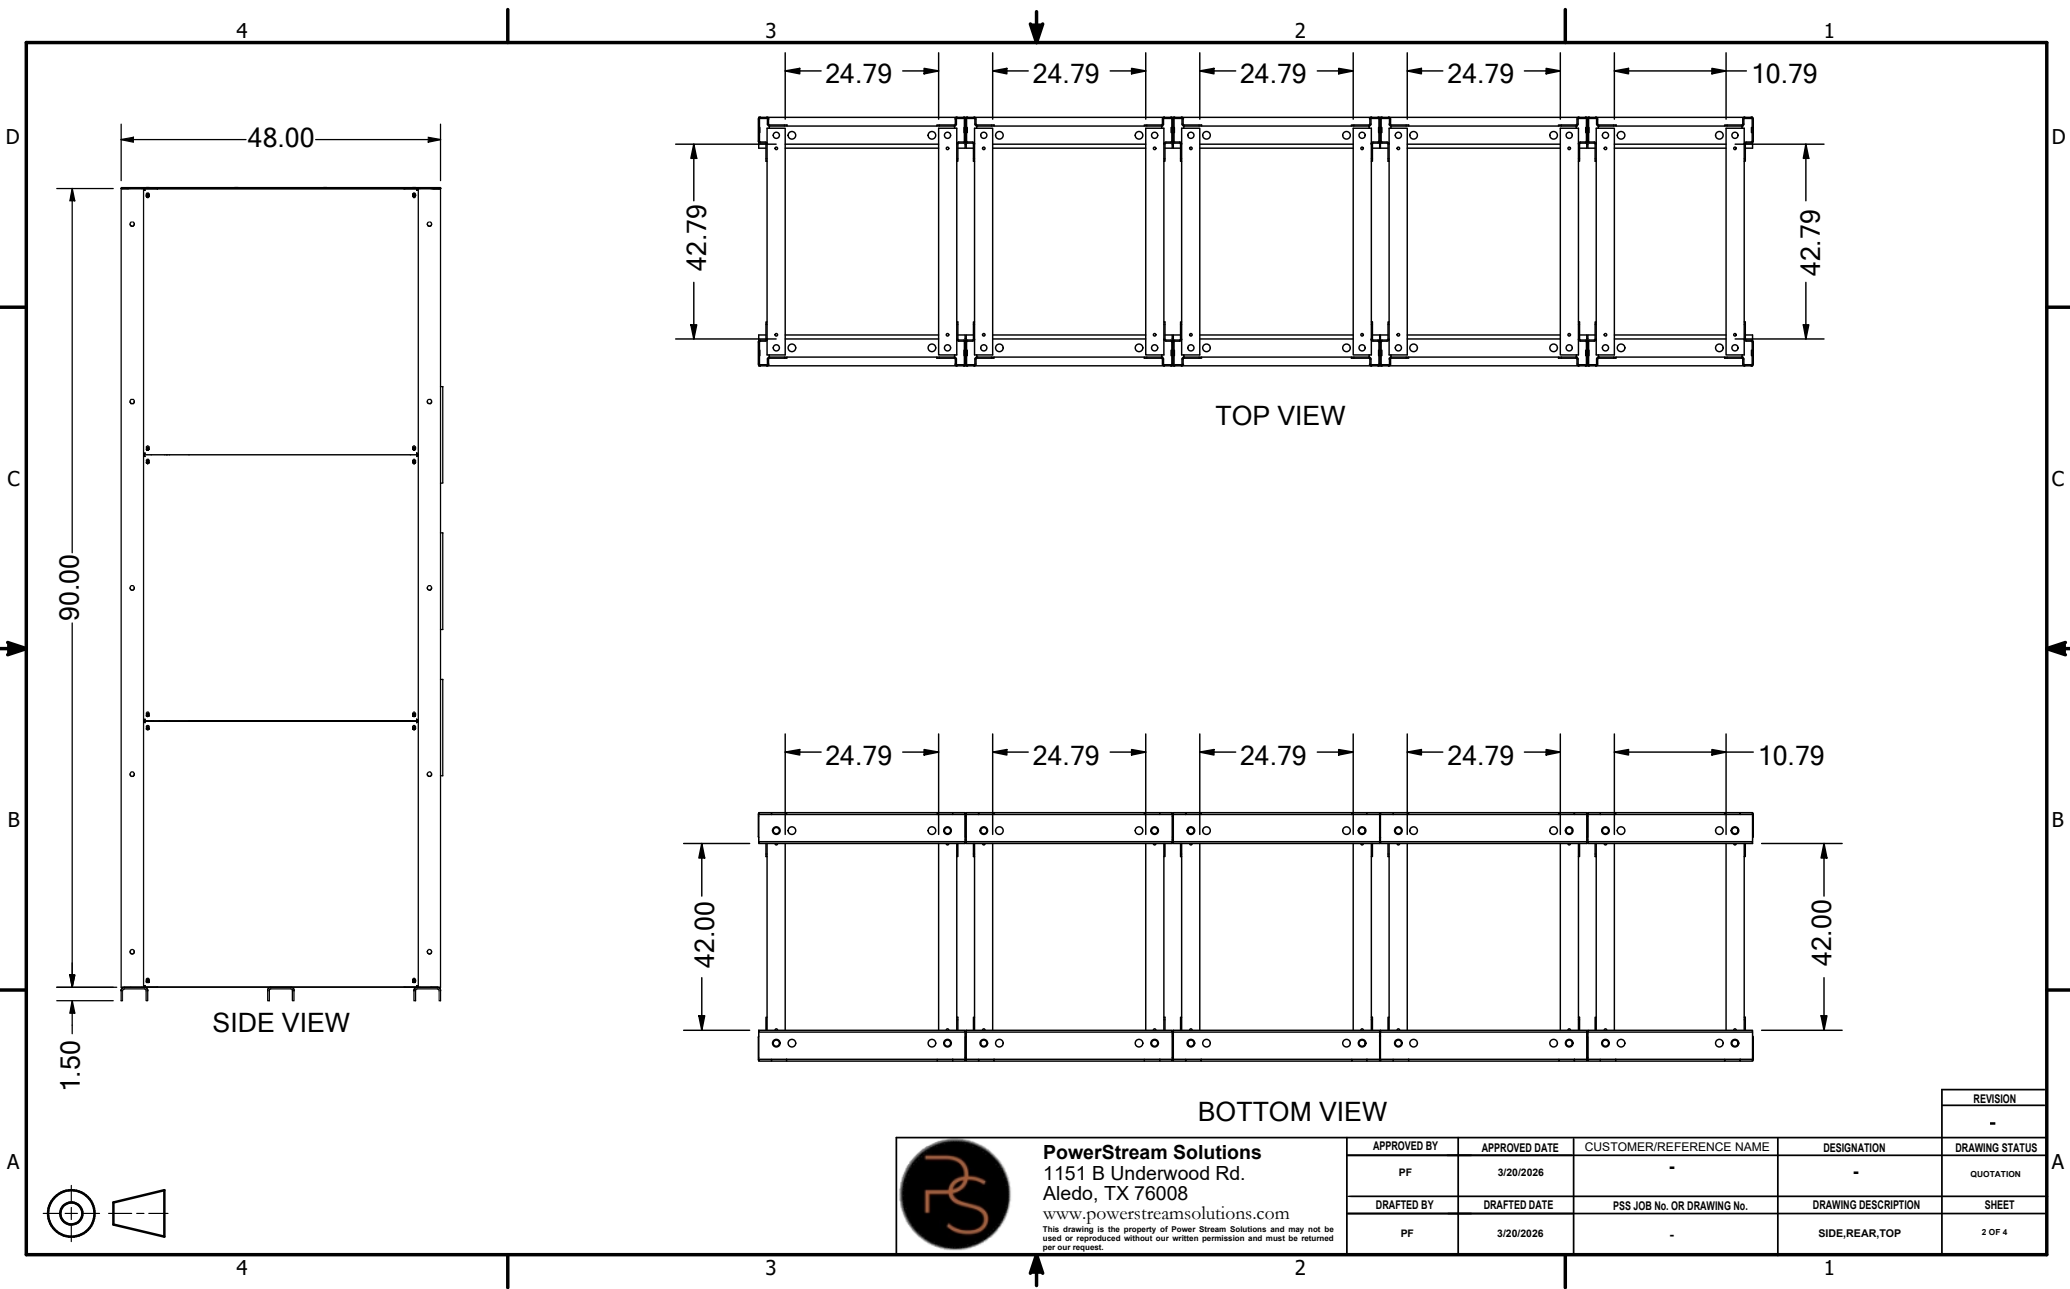

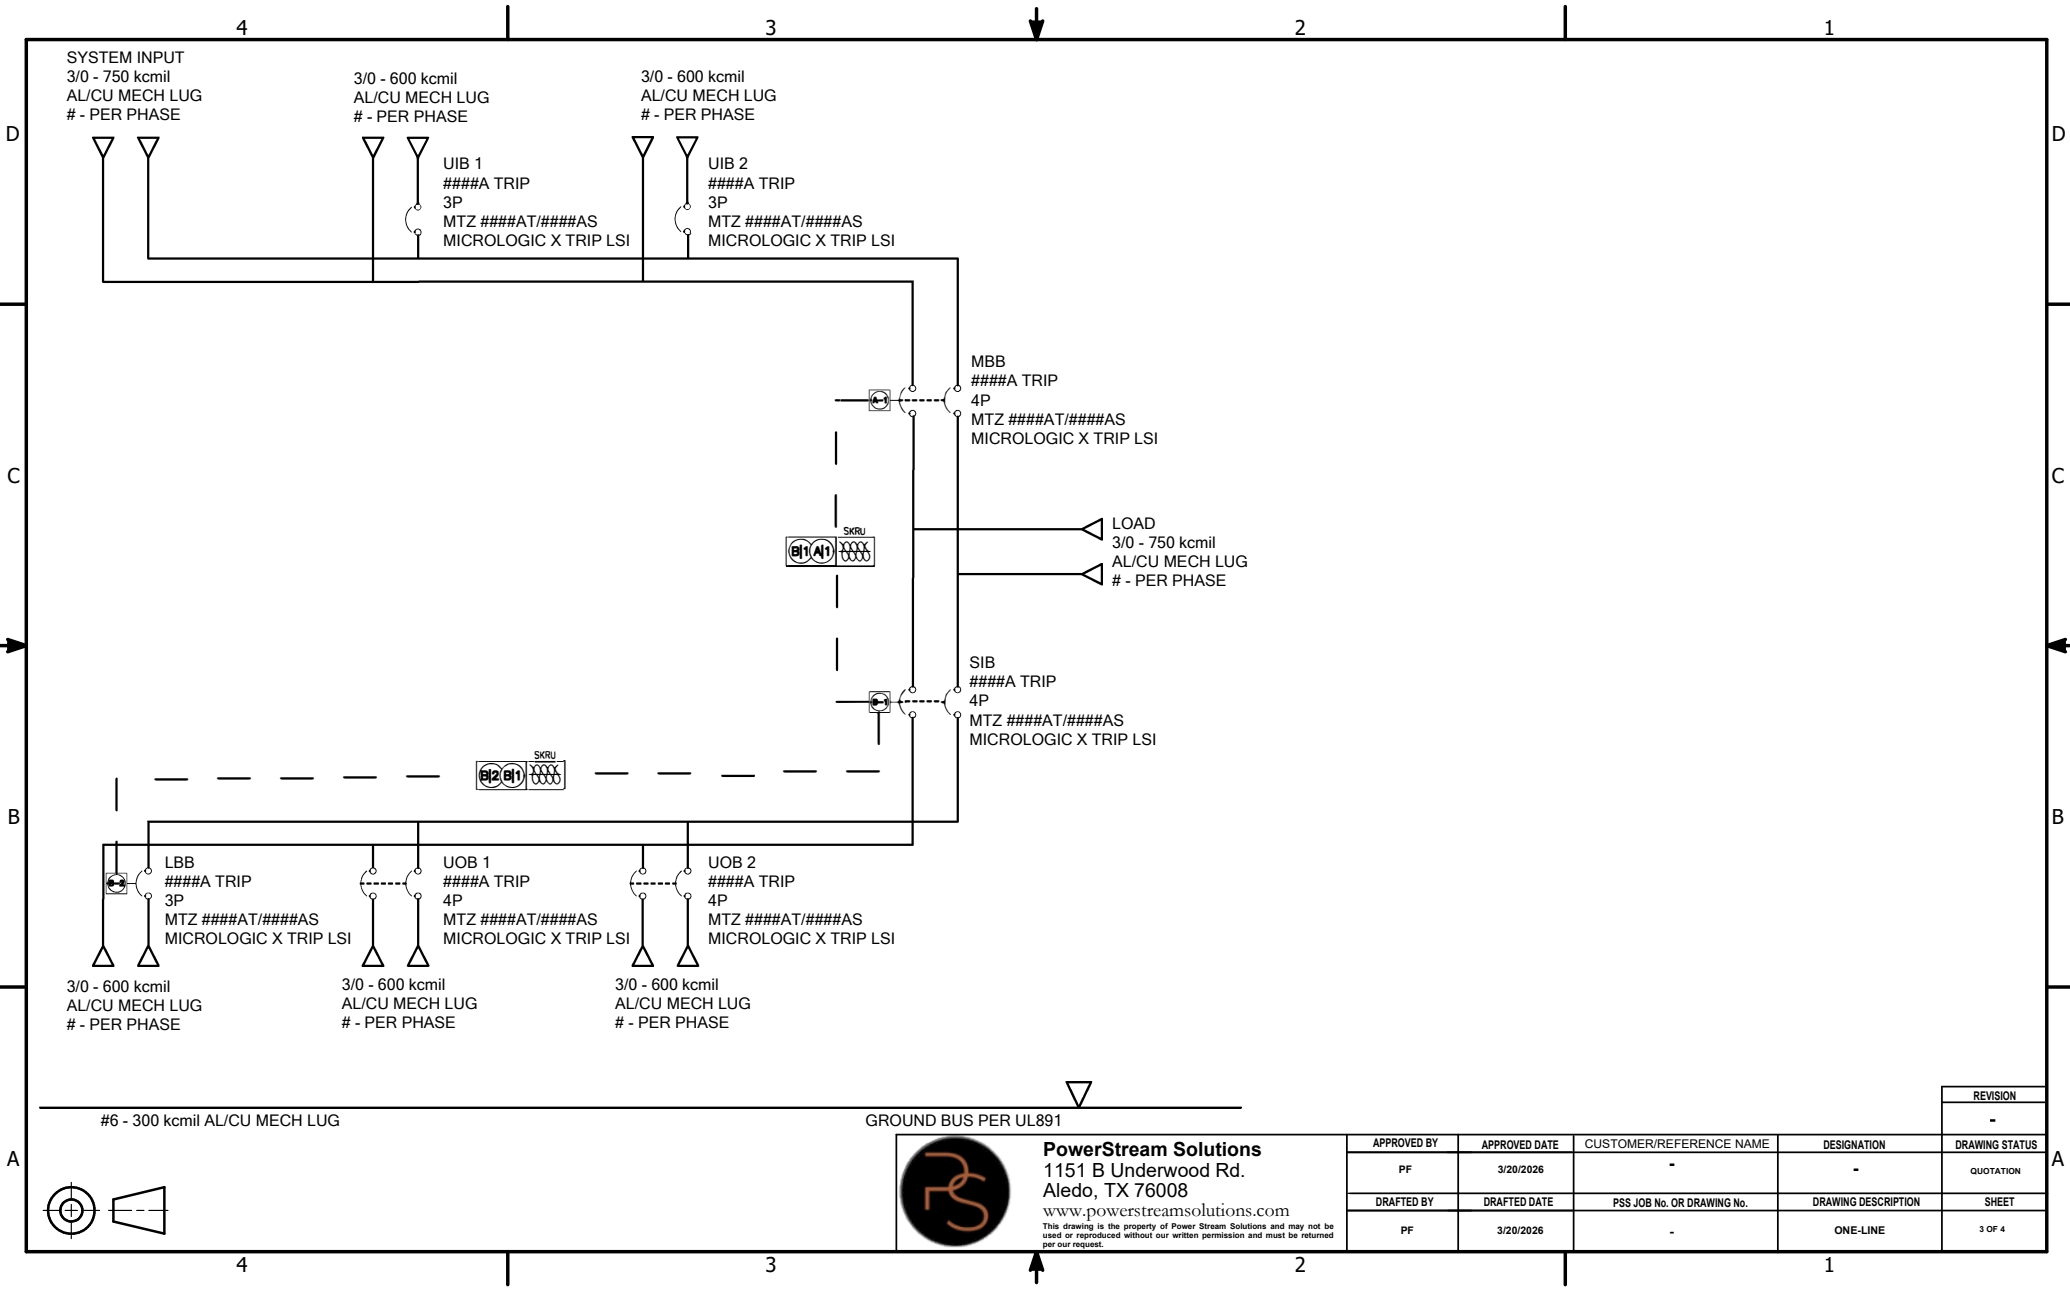

POWERSTREAM SOLUTIONS SWITCHBOARD													
SECT NO	CKT NO	IMD/ GMD CONFIG	DEVICE/FRAME RATING	TRIP AMP	FUSE/ TRIP	#P	DESIGNATION	N/P					ACCESSORIES / NOTES
									QTY	PHASE WIRE RANGE	QTY	NEUT WIRE RANGE	
1		FIX	-	-	-	-	SYSTEM INPUT	NO	#	3/0 - 750 kcmil	-	3/0 - 750 kcmil	
1		FIX	MTZ ####AF/####AS	####A	X-LSI	3P	LBB	NO	#	3/0 - #00 kcmil	-	3/0 - 750 kcmil	ERMS,KEY,OF4,PLA, SKRU,TU
2		FIX	MTZ ####AF/####AS	####A	X-LSI	3P	UIB 1	NO	#	3/0 - #00 kcmil	-	3/0 - 750 kcmil	ERMS,OF4,PLA,TU
2		FIX	MTZ ####AF/####AS	####A	X-LSI	3P	UOB 1	NO	#	3/0 - #00 kcmil	-	3/0 - 750 kcmil	ERMS,OF4,PLA,TU
3		FIX	MTZ ####AF/####AS	####A	X-LSI	3P	UIB 2	NO	#	3/0 - #00 kcmil	-	3/0 - 750 kcmil	ERMS,OF4,PLA,TU
3		FIX	MTZ ####AF/####AS	####A	X-LSI	3P	UOB 2	NO	#	3/0 - #00 kcmil	-	3/0 - 750 kcmil	ERMS,OF4,PLA,TU
4		FIX	MTZ ####AF/####AS	####A	X-LSI	4P	MBB	NO	#	3/0 - #00 kcmil	-	3/0 - 750 kcmil	ERMS,KEY,OF4,PLA, SKRU,TU
4		FIX	MTZ ####AF/####AS	####A	X-LSI	4P	SIB	NO	#	3/0 - #00 kcmil	-	3/0 - 750 kcmil	ERMS,KEY,OF4,PLA, SKRU,TU
5		FIX	-	-	-	-	LOAD	NO	#	3/0 - 750 kcmil	-	3/0 - 750 kcmil	

LEGEND	
ERMS	ENERGY REDUCTION MAINT. SWITCH
GF	GROUND FAULT
KEY	KEY INTERLOCK
OF4	4 FORM C BREAKER AUX CONTACTS
PLA	PADLOCK ATTACHMENT-FIXED
ST	SHUNT TRIP
SKRU	SOLENOID KEY RELEASE UNIT
TU	24VDC TRIP UNIT POWER SUPPLY

 

PowerStream Solutions
 1151 B Underwood Rd.
 Aledo, TX 76008
www.powerstreamolutions.com

This drawing is the property of Power Stream Solutions and may not be
 used or reproduced without our written permission and must be returned
 per our request.

APPROVED BY	APPROVED DATE	CUSTOMER/REFERENCE NAME	DESIGNATION	DRAWING STATUS
PF	3/20/2026	-	-	QUOTATION
DRAFTED BY	DRAFTED DATE	PSS JOB No. OR DRAWING No.	DRAWING DESCRIPTION	SHEET
PF	3/20/2026	-	ELECTRICAL COMP. SCHEDULE	4 OF 4